
Overall Site Plan

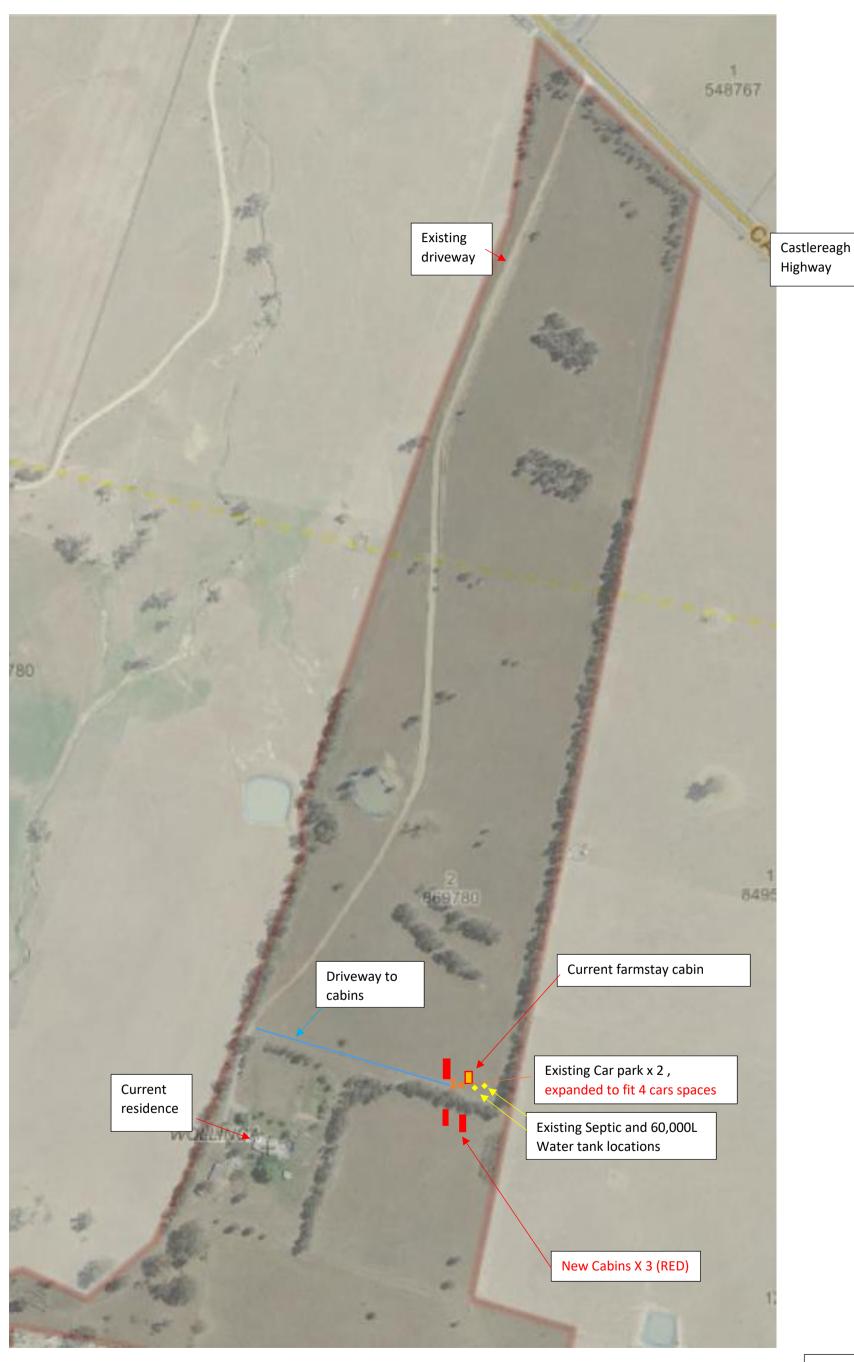



Lot 2 DP869780 344 Castlereagh Highway Spring Flat NSW 2850

GENERAL NOTES:

- * All materials and work practices shall comply with, but not limited to the Building Regulations 2006, National Construction Code Series 2013, building Code of Australia Vol 2 and all relevant current Australian Standards (as amended) referred to therein.
- * Unless otherwise specified, the term BCA shall refer to National Construction Code Series 2013 Building Code of Australia Vol 2.
- * All materials and construction practice shall meet the Performance requirements of the BCA. Where an alternative solution is proposed then, prior to implementation or installation, it first must be assessed and approved by the Relevant Building Surveyor as meeting the Performance Requirements
- * Glazing, including safety glazing, shall be installed to a size, type and thickness so as to comply with:
- BCA Part 3.6 for Class 1 and 10 Buildings within a design wind speed of not more then N3: and
- NCC 2013 BCA Vol 1 Part B1.4 for Class 2 and 9 Buildings.
- * Waterproofing of wet areas, being bathrooms, showers, shower rooms, laundries, sanitary compartments and the like shall be provided in accordance with AS 3740-2010: Waterproofing of Domestic Wet Areas.
- * These drawings shall be read in conjunction with any House Energy Rating (HERS) report and shall be constructed in accordance with the stamped plans endorsed by the accredited Thermal Performance Assessor without alterations.
- * Step sizes (other than for spiral stairs) to be:
- Risers (R) 190mm maximum and 115mm minimum.
- Going (G) 355mm maximum and 240mm minimum.
- -2R+1G'0 700mm maximum and 550mm minimum.
- with less than 125mm gap between open treads.
- * All treads, landings and the like to have non-slip finish or suitable non-skid strip near edge of nosing.
- * Provide balustrade where changes in level exceeds 1000mm above the surface beneath landings, ramps and/or treads. Balustrade (other than tensioned wire balustrade) to be:
- -1000mm minimum above finished surface level of balconies, landings or the like, and
- 865mm minimum above finished surface level of stair nosing or ramp and,
- vertical with less than 125mm gap between, and
- any horizontal element within the balustrade between 150mm and 760mm above the floor must not facilitate climbing where changes in level exceeds 4000mm above the surface beneath landings, ramps and/or treads.
- * Wire balustrade construction to comply with BCA Part 3.9.2.3 for Class 1 and 10 Buildings and NCC 2013 BCA Vol 1 Part D2.16 for other classes of
- * Top of handrails to be minimum 865mm vertically above stair nosing and
- * Window sizes nominated are nominal only. Actual size may vary according to manufacturer. Windows to be flashed all around.

- * Where the building (excluding a detached Class 10) is located in a termite prone area, the area to underside of building and perimeter is to be treated against termite attack.
- * Concrete stumps:
- Up to 1400mm long to be 100mm x 100mm (1 no. H.D. Wire)
- 1401mm to 1800mm long to be 100mm x 100mm (2 no. H.D. Wires)
- 1801mm to 3000mm long to be 125mm x 125mm (2 no. H.D. Wires) - 100mm x 100mm stumps exceeding 1200mm above ground level to be braced where no perimeter base brickwork provided.
- * For buildings in marine or other exposure environments shall have masonry units, mortar and all built in components and the like complying with the durability requirements of Table 4.1 of AS 4773.1-2010 'Masonry in small buildings' Part 1: Design.
- * All stormwater to be taken to the legal point of discharge to the Relevant Authorities approval.
- * These drawings shall be read in conjunction with all relevant structural and all other consultants' drawings/details and with any other written instructions issued in the course of the contract.
- * Site plan measurements in metres, all other measurements in millimetres u.n.o.
- * Figured dimensions take precedence over scaled dimensions.
- * the Builder shall take all steps necessary to ensure the stability and general water tightness of all new and/or existing structures during all works.
- * The Builder and Subcontractors shall check and verify all dimensions, setbacks, levels and specifications and all other relevant documentation prior to the commencement of any works. Report all discrepancies to the office
- * Installation of all services shall comply with the respective supply authority
- * The Builder and Subcontractors shall ensure that all stormwater drains. sewer pipes and the like are located at a sufficient distance from any buildings footing and.or slab edge beams so as to prevent general moisture penetration, dampness, weakening and undermining of any building and its
- * These plans have been prepared for the exclusive use by the client of Avallon Building Design and Drafting ('The Designer') for the purpose expressly notified to the Designer. Any other person who uses or relies on these plans without the Designer's written consent does to at their own risk and no responsibility is accepted by the Design for such use and/or reliance.
- * The approval by this office of a substitute material, work practice, variation or the like is not an authorisation for its use or a contract variation. Any said variations must be accepted by all parties to the agreement and where applicable the Relevant Building Surveyor prior to implementing the said

STORMWATER

90mm DIA. Class 6 UPVC stormwater line laid to a minimum grade of 1:100 and connected to the legal point of stormwater discharge. Provide inspection openings at 9000mm C/C and at each change of direction.

The cover to underground stormwater drawings shall be not less than

- 100mm under soil
- 50mm under paved or concrete areas
- 100mm under unreinforced concrete or paved driveways
- 75mm under reinforced concrete driveways

SITE ENVIRONMENT DESIGN INFORMATION

Refer report by others
Reference document AS 3959—2009 Construction of Buildings in Bushfire prone areas

Site Classification Site classification as Class: '??' Refer soil report No: ?? Dated: ??

Design Gust Wind Speed / Wind Classification

Building tie-downs to be provided in accordance with AS1684-2006 for an assumed design gust wind speed / wind classification of N2 (subject to confirmation on site by Relevant Building Surveyor at first inspection) refer to AS1684 for construction requirements.

Climate zone for Thermal design / Thermal performance assessment:

<u>Corrosion protection of built—in structural members</u>

Provide corrosion protection of built—in structural steel members such as steel lintels, shelf angles, connectors, accessories (other than wall ties) in accordance with Table 4.1 of AS 4773.1-2010 Masonry in Small Buildings, Part 1: Design suitable for an Environment Classification of

Corrosion protection for sheet roofing

Provide corrosion protection for sheet roofing in accordance with BCA Table 3.5.1a suitable for an Environment Classification of




DO NOT SCALE OFF DRAWINGS. ALL DIMENSIONS TO BE CHECKED

Proposed: Transportable Studio

344 Castlereagh Hwy, Spring Flat NSW

Alina & Mick Client:

Soul Space Studios For:-

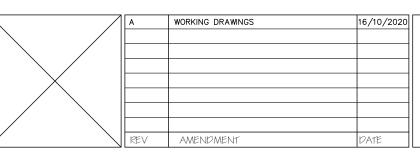

\nearrow	Avallon
	Building
	Design
,	5

PO Box 170 Trafalgar Vic. 3824 Mob. 0419 598 662 E. design@avallon.com.au

]	Design Methers where		
		Ļ	

© COPYRIGHT '2020' This document or any document form part of this document remains the property of Avallon Building Design or Drafting and may not be retained, copied or altered in whole or in part, used without the written permission

		PRIOR TO CO	MMENCE	MENT	OF	WORKS
ıbor	1111.15	Working Drawings General Note				
	Scale	N/A	Date	16/	10/	′202C
ng	Drawn	MG	Job No.	1		
or	Issue	A	Sheet	1 of	6	

FLOOR AREAS:

48.0 m sqr 5.17 sqr 24.0 m sqr 2.58 sqr DECK:

ENERGY RATING REQUIREMENTS

- R6.0 INSULATION TO CEILING/ROOF - R2.7 INSULATION TO EXTERNAL WALLS & INTERNAL WALLS SHOWN
- R2.0 INSULATION UNDER FLOOR
- ALUMINIUM AWNING DOUBLE GLAZED WINDOWS:
- U-VALUE 4.5, SHGC VALUE 0.5 OR BETTER - ALUMINIUM FIXED DOUBLE GLAZED WINDOWS: U-VALUE 4.5, SHGC VALUE 0.61 OR BETTER
- ALUMINIUM DOUBLE GLAZED SLIDING DOORS: U-VALUE 4.5, SHGC VALUE 0.5 OR BETTER

NOTES:

- WINDOW SIZES SHOWN ARE INDICATIVE ONLY AND MAY VARY. REFER TO WNDOW MANUFACTURERS SPECIFICATIONS FOR ACTUAL WINDOW SIZES, DETAILS AND STUD OPENINGS. - These drawings to be read in CONJUNCTION WITH ENGINEERS SPECIFICATIONS AND DRAWINGS. ENGINEERED MEMBER SIZES TO TAKE PRECEDENCE.

- DIMENSIONS SHOWN ARE TO FRAME ONLY. HARD WIRED SMOKE DETECTORS WITH BATTERY BACKUP IN ACCORDANCE WITH A.S.


3786-1993 & B.C.A.

– DownPipes connected to LPOD via 90ϕ UPVC PIPE AS PER LOCAL AUTHORITIES

REQUIREMENTS. REFER SITE PLAN. SB - SUB-BOARD FUSE BOX

WHERE SHOWN

- PROVIDE FLOOR TILES TO WET AREAS. - R2.7 INSULATION TO INTERNAL WALLS

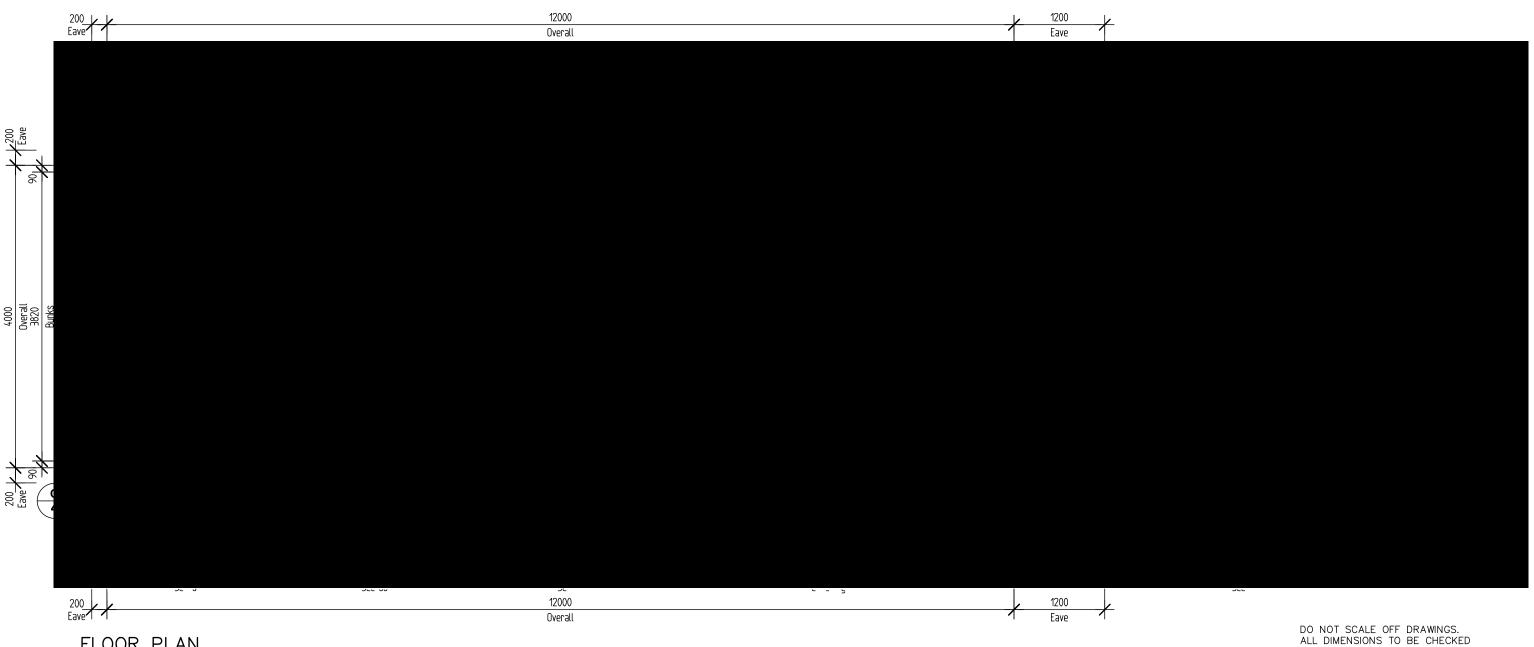


FLOOR PLAN

Proposed: Transportable Studio

344 Castlereagh Hwy, Spring Flat NSW At:

Client: Alina & Mick

 Soul Space Studios For :-



Α	WORKING DRAWINGS	16/10/20
REV	AMENDMENT	DATE




PO Box 170 Trafalgar Vic. 3824 Mob. 0419 598 662 E. design@avallon.com.au




C COPYRIGHT '2020' This document or any document forming part of this document remains the property of Availon Building Design & Drafting and may not be retained, copied or altered in whole or in part, or used without the written permission.

	PRIOR TO CO	MMENCE	MENI	OF	WORK
111LE	Working Drawings Floor Plan	:-			
Scale .	1:50	Date	16/	10,	/20
Drawn	MG	Job No.	1		
Issue	Α	Sheet	2 0	f 6	

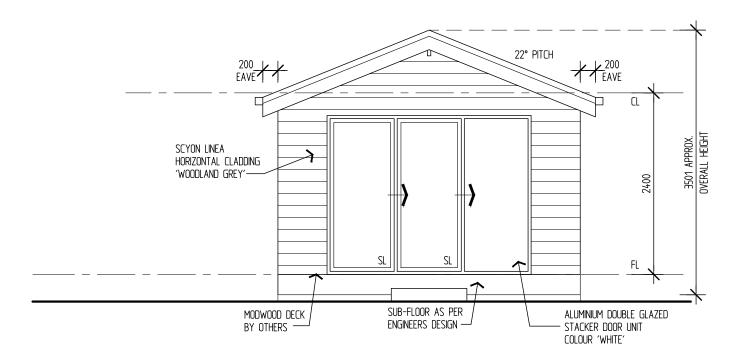

ELEVATION A

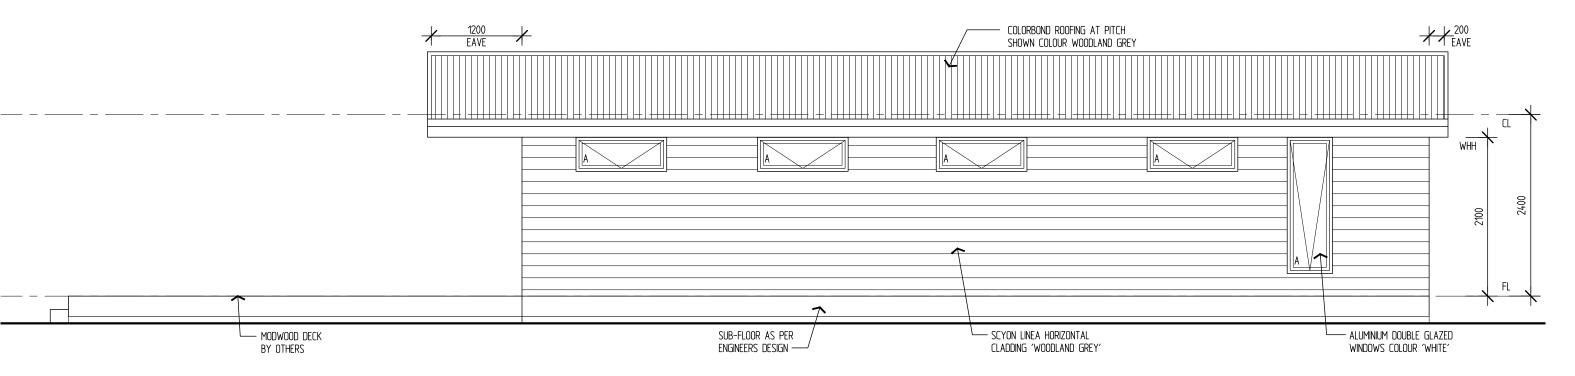

ELEVATION B

DO NOT SCALE OFF DRAWINGS. ALL DIMENSIONS TO BE CHECKED PRIOR TO COMMENCEMENT OF WORKS.

16/10/20

3 of 6

Proposed: Transportable Studio

344 Castlereagh Hwy, Spring Flat NSW


Alina & Mick Client :

Soul Space Studios For :-


A	WORKING DRAWINGS	16/10/20
\		
$X \Vdash$		
/ \ -		
, RE	V AMENDMENT	DATE

Avallon Building Design

Avallon Building	4 Deelgn 95 Methers number	TITLE	Working Drawings Elevations	:-	
Design		Scale	1:50	Date	16,
1 2 3 3 7 9 7 9	C COPYRIGHT '2020' This document or any document forming part of this document remains the property of Availon Building Design &	Drawn	MG	Job No.	1
PO Box 170 Trafalgar Vic. 3824 Mob. 0419 598 662 E. design@avallon.com.au	Drafting and may not be retained, copied or altered in whole or in part, or used without the written permission.	Issue	Α	Sheet	3

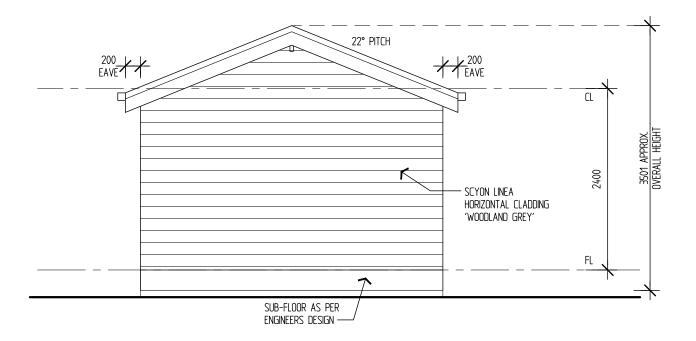

ELEVATION C

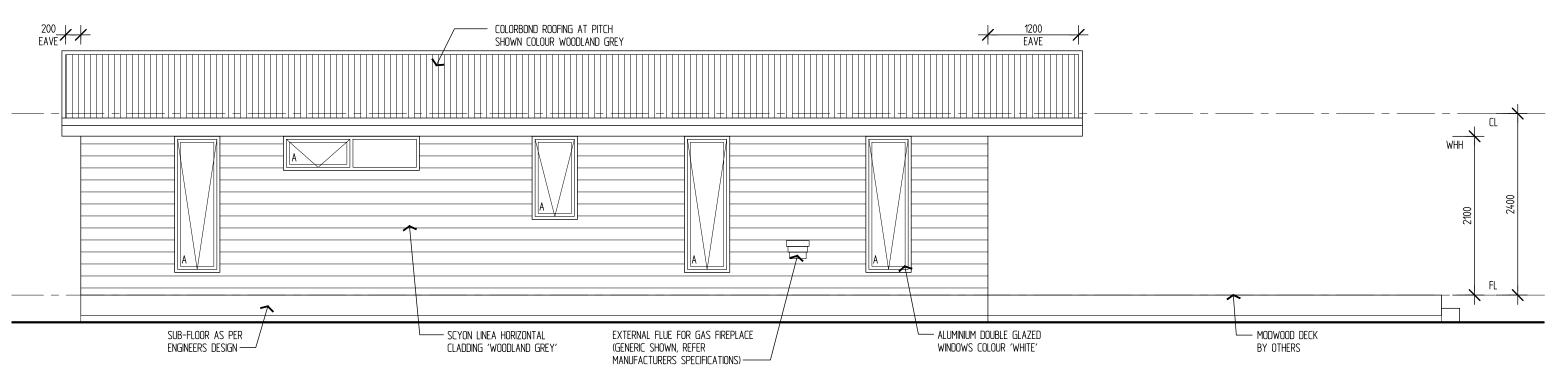

ELEVATION D


DO NOT SCALE OFF DRAWINGS. ALL DIMENSIONS TO BE CHECKED PRIOR TO COMMENCEMENT OF WORKS.

Proposed: Transportable Studio

344 Castlereagh Hwy, Spring Flat NSW

Alina & Mick Client :


Soul Space Studios For :-

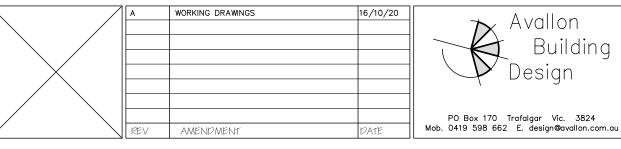




	© COPYRIGHT '2020' This document or only document forming part of this document remains the property of Availon Building Design & cooled or altered in whole or in part, or
- 1	used without the written permission.

111LE	Working Drawings Elevations	:-	
5cale	1:50	Date	16/10/20
Drawn	MG	Job No.	1
Issue	А	Sheet	4 of 6

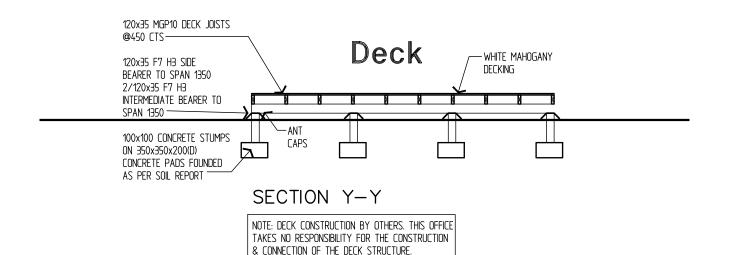

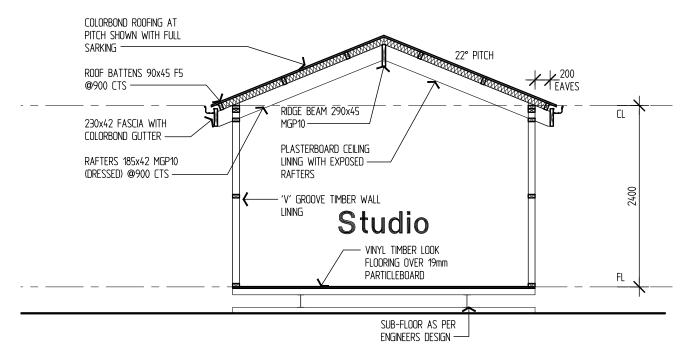

SECTION X-X

STUD SCHEDULE

MEMBER	SIZE	GRADE	CTS	SPAN
STUDS	90x45	F5	350	1200
NOGGINGS	70x35	F5	1200	
L/BEAR. TOP PLATE	2/90x45	F5		
TOP & BOTTOM PLATE	90x45	F5		
JAMB STUD	2/90x35	F5		1250
JAMB STUD	2/90x45	F5		2500
LINTEL	120x35	MGP10		1250
LINTEL	190x45	MGP10		2500

SOIL CLASSIFICATION CLASS: '?' REFER TO SOIL REPORT BY: ??

DATED: ??

REPORT NO: ??

NOTE:

- PROVIDE TERMITE TREATMENT TO A.S. 3660.1
- These drawings to be read in conjunction with ENGINEERS SPECIFICATIONS. ENGINEERS DETAILS AND SIZES TO TAKE PRECEDENCE.

ENERGY RATING REQUIREMENTS


- R6.0 INSULATION TO CEILING
- R2.7 INSULATION TO EXTERNAL WALLS
- R2.7 INSULATION TO BATH INTERNAL WALLS
- R2.0 INSULATION TO UNDER FLOOR
- ALUMINIUM AWNING DOUBLE GLAZED WINDOWS: U-VALUE 4.5, SHGC VALUE 0.5 OR BETTER
- ALUMINIUM FIXED DOUBLE GLAZED WINDOWS: U-VALUE 4.5, SHGC VALUE 0.61 OR BETTER
- ALUMINIUM DOUBLE GLAZED STACKER DOOR: U-VALUE 4.5, SHGC VALUE 0.5 OR BETTER

Proposed: Transportable Studio

344 Castlereagh Hwy, Spring Flat NSW

Client: Alina & Mick

Soul Space Studios For :-

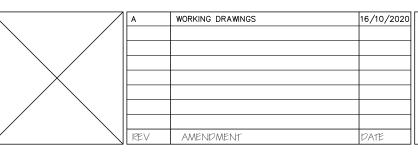



PO Box 170 Trafalgar Vic. 3824 Mob. 0419 598 662 E. design@avallon.com.au

	4 Deelgn 15 Metters name stations	111 5c
- 1		

C COPYRIGHT '2020' his document or any document forming part of this document remains the property of Avallon Building Design & Drafting and may not be retained, opied or altered in whole or in part, or used without the written permission

	PRIOR TO CO	MMENCEMENT OF WORKS
TITLE	Working Drawings Section	:-
Scale	1:50	Date 16/10/2020
Drawn	MG	Job No. 1
Issue	А	Sheet 5 of 6

DO NOT SCALE OFF DRAWINGS. ALL DIMENSIONS TO BE CHECKED

ELECTRICAL LEGEND


- DOUBLE POWER POINT
- DOUBLE WEATHERPROOF POWER POINT
- © CEILING MOUNTED SPOTLIGHT
- ◆ SMOKE DETECTOR
- OO IXL TASTIC HEAT/FAN/LIGHT
- SELF-SEALING CEILING EXHAUST FAN
- CEILING EXHAUST FAN SWITCHED WITH LIGHT (SELF-SEALING)
- EXTERNAL SPOT LIGHT
- ₩ TV POINT
- PHONE POINT
- CEILING FAN WITH LIGHT
- ✓ SECURITY SENSOR
- SUB-BOARD FUSE BOX

- NOTES: LOCATIONS OF ALL ELECTRICAL AND SERVICE POINTS ARE APPROXIMATE ONLY AND SUBJECT TO POSITIONS OF STRUCTURAL MEMBERS.
- PROVIDE SMOKE DETECTORS WHERE INDICATED IN ACCORDANCE WITH A.S. 3786-1993 AND B.C.A.

WATTAGE ALLOWANCE:

Max. total wattage residence: 5 W/m sqr Residence floor area: 48m sqr Total allowable wattage: 240 W Total No. of lights: 15 MAX. WATTAGE PER LIGHT: 16 W

NOTE: PERIMETER LIGHTING MUST BE EITHER CONTROLLED BY A DAYLIGHT SENSOR, OR HAVE AN AVERAGE LIGHT SOURCE EFFICACY OF NOT LESS THAN 40 LUMENS/W, AS PER

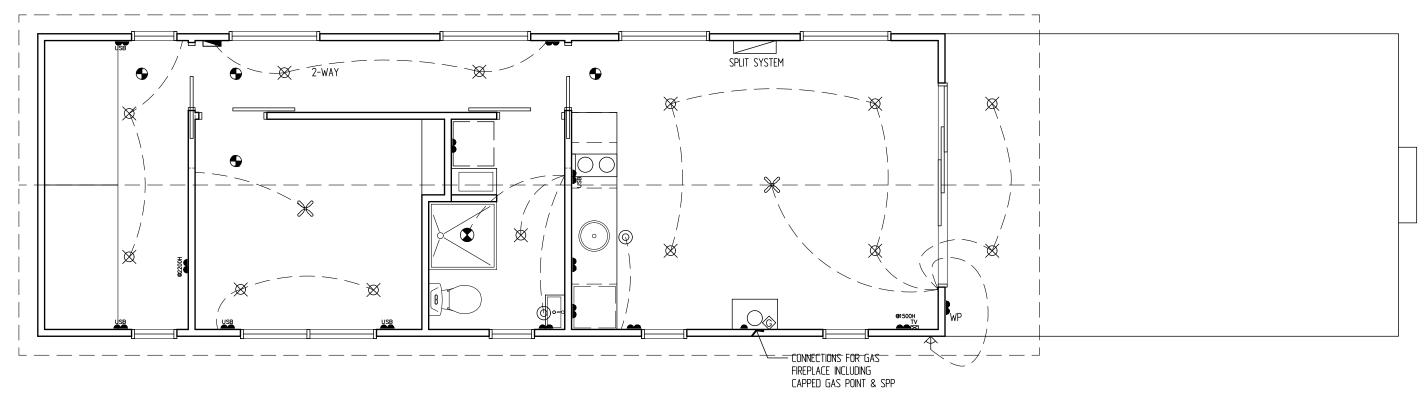

ELECTRICAL PLAN


DO NOT SCALE OFF DRAWINGS. ALL DIMENSIONS TO BE CHECKED PRIOR TO COMMENCEMENT OF WORKS.

Proposed: Transportable Studio

344 Castlereagh Hwy, Spring Flat NSW

Client : Alina & Mick

Soul Space Studios For :-

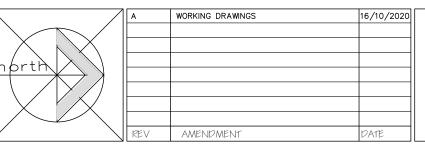



PO Box 170 Trafalgar Vic. 3824 used without the written permission Mob. 0419 598 662 E. design@avallon.com.au

4 Deelgn 17 Methers name	TITLE	Working Drawings Electrical Plan		
	Scale	1:50	Date	16/10/2020
C COPYRIGHT '2020' This document or any document forming part of this document remains the property of Availan Building Design &	Drawn	MG	Job No.	1
Drafting and may not be retained, copied or altered in whole or in part, or used without the written permission.	Issue	Α	Sheet	6 of 6

GENERAL NOTES:

- * All materials and work practices shall comply with, but not limited to the Building Regulations 2006, National Construction Code Series 2013, building Code of Australia Vol 2 and all relevant current Australian Standards (as amended) referred to therein.
- * Unless otherwise specified, the term BCA shall refer to National Construction Code Series 2013 Building Code of Australia Vol 2.
- * All materials and construction practice shall meet the Performance requirements of the BCA. Where an alternative solution is proposed then, prior to implementation or installation, it first must be assessed and approved by the Relevant Building Surveyor as meeting the Performance Requirements
- * Glazing, including safety glazing, shall be installed to a size, type and thickness so as to comply with:
- BCA Part 3.6 for Class 1 and 10 Buildings within a design wind speed of not more then N3: and
- NCC 2013 BCA Vol 1 Part B1.4 for Class 2 and 9 Buildings.
- * Waterproofing of wet areas, being bathrooms, showers, shower rooms, laundries, sanitary compartments and the like shall be provided in accordance with AS 3740-2010: Waterproofing of Domestic Wet Areas.
- * These drawings shall be read in conjunction with any House Energy Rating (HERS) report and shall be constructed in accordance with the stamped plans endorsed by the accredited Thermal Performance Assessor without alterations.
- * Step sizes (other than for spiral stairs) to be:
- Risers (R) 190mm maximum and 115mm minimum.
- Going (G) 355mm maximum and 240mm minimum.
- ř ÌG´0 700mm maximum and 550mm minimum.
- with less than 125mm gap between open treads.
- * All treads, landings and the like to have non-slip finish or suitable non-skid strip near edge of nosing.
- * Provide balustrade where changes in level exceeds 1000mm above the surface beneath landings, ramps and/or treads. Balustrade (other than tensioned wire balustrade) to be:
- -1000mm minimum above finished surface level of balconies, landings or the like, and
- 865mm minimum above finished surface level of stair nosing or ramp and,
- vertical with less than 125mm gap between, and
- any horizontal element within the balustrade between 150mm and 760mm above the floor must not facilitate climbing where changes in level exceeds 4000mm above the surface beneath landings, ramps and/or treads.
- * Wire balustrade construction to comply with BCA Part 3.9.2.3 for Class 1 and 10 Buildings and NCC 2013 BCA Vol 1 Part D2.16 for other classes of
- * Top of handrails to be minimum 865mm vertically above stair nosing and
- * Window sizes nominated are nominal only. Actual size may vary according to manufacturer. Windows to be flashed all around.

- * Where the building (excluding a detached Class 10) is located in a termite prone area, the area to underside of building and perimeter is to be treated against termite attack.
- * Concrete stumps:
- Up to 1400mm long to be 100mm x 100mm (1 no. H.D. Wire)
- 1401mm to 1800mm long to be 100mm x 100mm (2 no. H.D. Wires)
- 1801mm to 3000mm long to be 125mm x 125mm (2 no. H.D. Wires) - 100mm x 100mm stumps exceeding 1200mm above ground level to be braced where no perimeter base brickwork provided.
- * For buildings in marine or other exposure environments shall have masonry units, mortar and all built in components and the like complying with the durability requirements of Table 4.1 of AS 4773.1-2010 'Masonry in small buildings' Part 1: Design.
- * All stormwater to be taken to the legal point of discharge to the Relevant Authorities approval.
- * These drawings shall be read in conjunction with all relevant structural and all other consultants' drawings/details and with any other written instructions issued in the course of the contract.
- * Site plan measurements in metres, all other measurements in millimetres u.n.o.
- * Figured dimensions take precedence over scaled dimensions.
- * the Builder shall take all steps necessary to ensure the stability and general water tightness of all new and/or existing structures during all works.
- * The Builder and Subcontractors shall check and verify all dimensions, setbacks, levels and specifications and all other relevant documentation prior to the commencement of any works. Report all discrepancies to the office
- * Installation of all services shall comply with the respective supply authority
- * The Builder and Subcontractors shall ensure that all stormwater drains. sewer pipes and the like are located at a sufficient distance from any buildings footing and or slab edge beams so as to prevent general moisture penetration, dampness, weakening and undermining of any building and its
- * These plans have been prepared for the exclusive use by the client of Avallon Building Design and Drafting ('The Designer') for the purpose expressly notified to the Designer. Any other person who uses or relies on these plans without the Designer's written consent does to at their own risk and no responsibility is accepted by the Design for such use and/or reliance.
- * The approval by this office of a substitute material, work practice, variation or the like is not an authorisation for its use or a contract variation. Any said variations must be accepted by all parties to the agreement and where applicable the Relevant Building Surveyor prior to implementing the said

STORMWATER

90mm DIA. Class 6 UPVC stormwater line laid to a minimum grade of 1:100 and connected to the legal point of stormwater discharge. Provide inspection openings at 9000mm C/C and at each change of direction.

The cover to underground stormwater drawings shall be not less than

- 100mm under soil
- 50mm under paved or concrete areas
- 100mm under unreinforced concrete or paved driveways
- 75mm under reinforced concrete driveways

SITE ENVIRONMENT DESIGN INFORMATION

Refer report by others
Reference document AS 3959—2009 Construction of Buildings in Bushfire prone areas

Site Classification

Site classification as Class: 'H1' Refer soil report No: 35145 By: Barnsons Dated: 19/11/20

<u>Design Gust Wind Speed / Wind Classification</u>

Building tie-downs to be provided in accordance with AS1684-2006 for an assumed design gust wind speed / wind classification of N2 (subject to confirmation on site by Relevant Building Surveyor at first inspection) refer to AS1684 for construction requirements.

Climate Zone

Climate zone for Thermal design / Thermal performance assessment:

<u>Corrosion protection of built—in structural members</u> Provide corrosion protection of built—in structural steel members such as

steel lintels, shelf angles, connectors, accessories (other than wall ties) in accordance with Table 4.1 of AS 4773.1—2010 Masonry in Small Buildings, Part 1: Design suitable for an Environment Classification of

Corrosion protection for sheet roofing

Provide corrosion protection for sheet roofing in accordance with BCA Table 3.5.1a suitable for an Environment Classification of




DO NOT SCALE OFF DRAWINGS. ALL DIMENSIONS TO BE CHECKED

Proposed: Transportable Studio

344 Castlereagh Hwy, Spring Flat NSW

Client: Alina & Mick

Soul Space Studios For:-

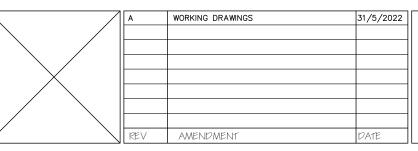

7>	Avallon
	Building
	Design

PO Box 170 Trafalgar Vic. 3824 Mob. 0419 598 662 E. design@avallon.com.au

l	© COPYRIGHT '2020'
	This document or any document forming part of this document remains the property of Avallon Building Design &
	Drafting and may not be retained, copied or altered in whole or in part, or used without the written permission.

		PRIOR TO COM	MMENCEMENT OF WORK
P	1111.15	Working Drawings General Notes	
	Scale	N/A	Date 31/5/22
	Drawn	MG	Job No. 1
	Issue	А	Sheet 1 of 6

FLOOR AREAS:

48.0 m sgr 5.17 sgr DECK: 24.0 m sqr 2.58 sqr

ENERGY RATING REQUIREMENTS

- R6.0 INSULATION TO CEILING/ROOF - R2.7 INSULATION TO EXTERNAL WALLS & INTERNAL WALLS SHOWN
- R2.0 INSULATION UNDER FLOOR
- ALUMINIUM AWNING DOUBLE GLAZED WINDOWS: U-VALUE 4.5, SHGC VALUE 0.5 OR BETTER - ALUMINIUM FIXED DOUBLE GLAZED WINDOWS: U-VALUE 4.5, SHGC VALUE 0.61 OR BETTER

- ALUMINIUM DOUBLE GLAZED SLIDING DOORS: U-VALUE 4.5, SHGC VALUE 0.5 OR BETTER

NOTES:


- WINDOW SIZES SHOWN ARE INDICATIVE ONLY AND MAY VARY. REFER TO WNDOW MANUFACTURERS SPECIFICATIONS FOR ACTUAL WINDOW SIZES, DETAILS AND STUD OPENINGS. - These drawings to be read in CONJUNCTION WITH ENGINEERS SPECIFICATIONS AND DRAWINGS. ENGINEERED MEMBER SIZES TO TAKE PRECEDENCE.

- DIMENSIONS SHOWN ARE TO FRAME ONLY. - HARD WIRED SMOKE DETECTORS WITH BATTERY BACKUP IN ACCORDANCE WITH A.S. 3786-1993 & B.C.A.

- DownPipes connected to LPOD via 90\$ UPVC PIPE AS PER LOCAL AUTHORITIES

REQUIREMENTS. REFER SITE PLAN. SB - SUB-BOARD FUSE BOX

- PROVIDE FLOOR TILES TO WET AREAS. - R2.7 INSULATION TO INTERNAL WALLS WHERE SHOWN

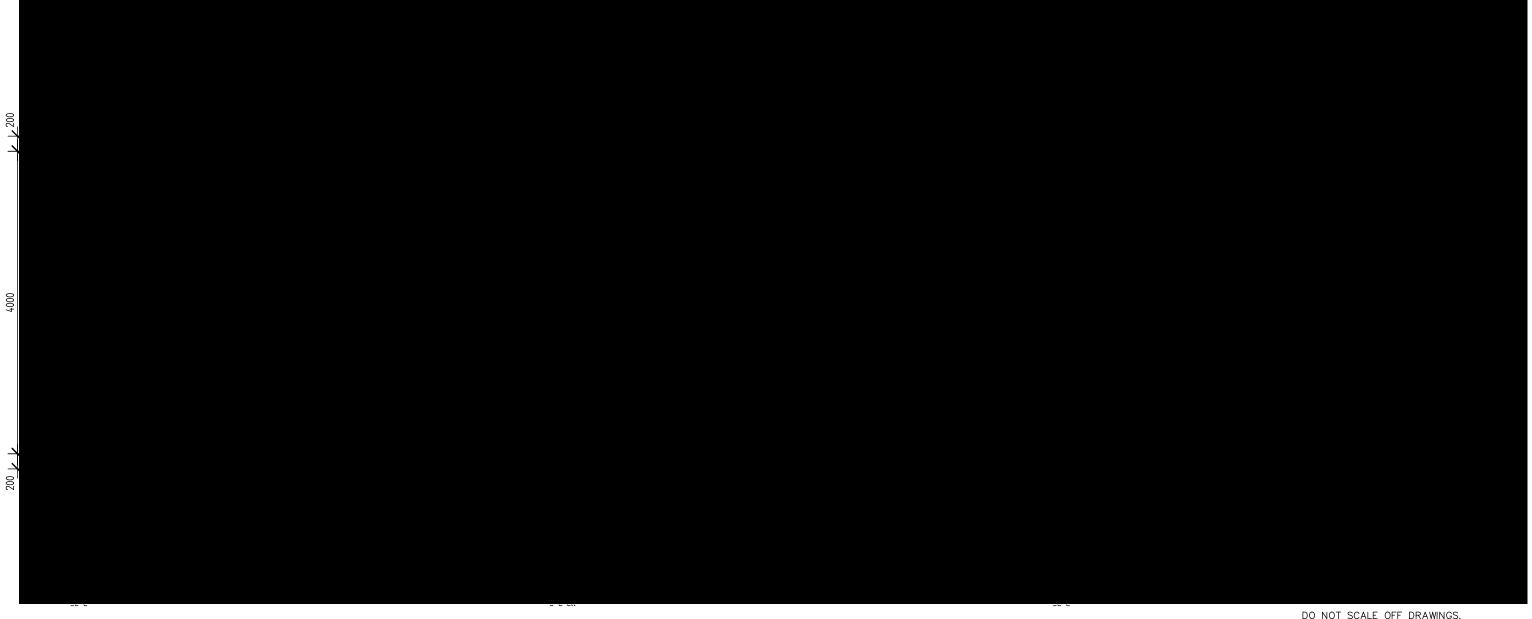


FLOOR PLAN

Proposed: Transportable Studio

344 Castlereagh Hwy, Spring Flat NSW At:

Client: Alina & Mick

Soul Space Studios For :-

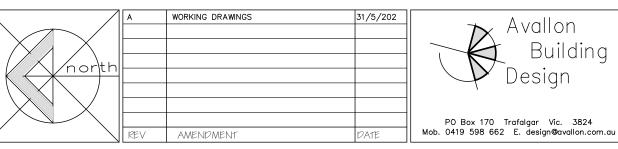




PO Box 170 Trafalgar Vic. 3824

C COPYRIGHT '2020' This document or any document forming part of this document remains the property of Avallon Building Design & Drafting and may not be retained, copied or altered in whole or in part, oused without the written permission.


		ALL DIMENSIONS TO BE CHECKED PRIOR TO COMMENCEMENT OF WOR
4 Deelgn 17 Methers name	111LE	Working Drawings :— Floor Plan
	Scale	1.50 Pate 31/5/22

)rawings : lan 31/5/22 1:50 MG 2 of 6 Α

TO COMMENCEMENT OF WORKS.

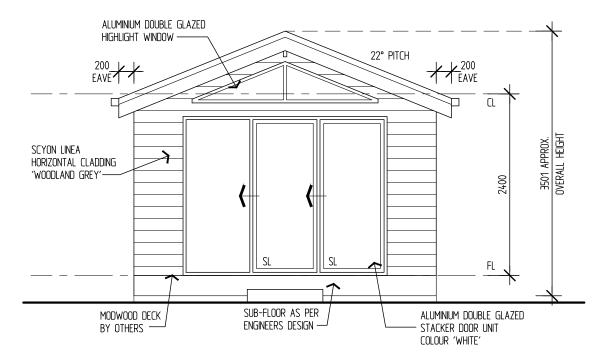

ELEVATION A

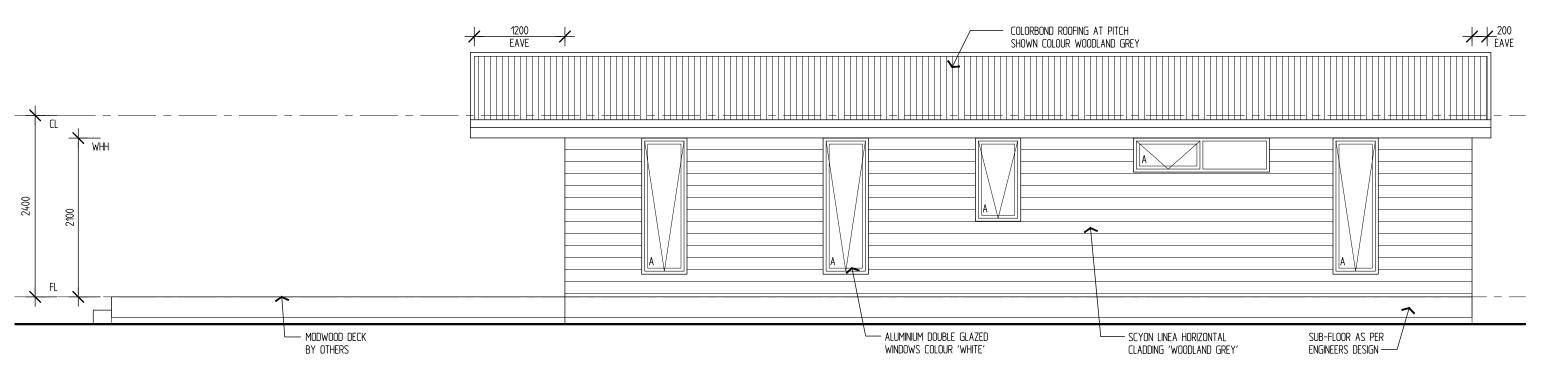

ELEVATION B


DO NOT SCALE OFF DRAWINGS. ALL DIMENSIONS TO BE CHECKED PRIOR TO COMMENCEMENT OF WORKS.

Proposed: Transportable Studio

At: 344 Castlereagh Hwy, Spring Flat NSW


Client: Alina & Mick

For: Soul Space Studios

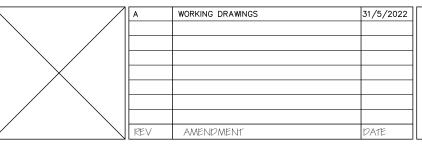




17 Design mater	111LE	Working Drawings Elevations	:-	
	Scale	1:50	Date	31/5/22
© COPYRIGHT '2020' This document or any document forming part of this document remains the property of Availon Building Design &	Drawn	MG	Job No.	1
Drafting and may not be retained, copied or altered in whole or in part, or used without the written permission.	Issue	А	Sheet	3 of 6

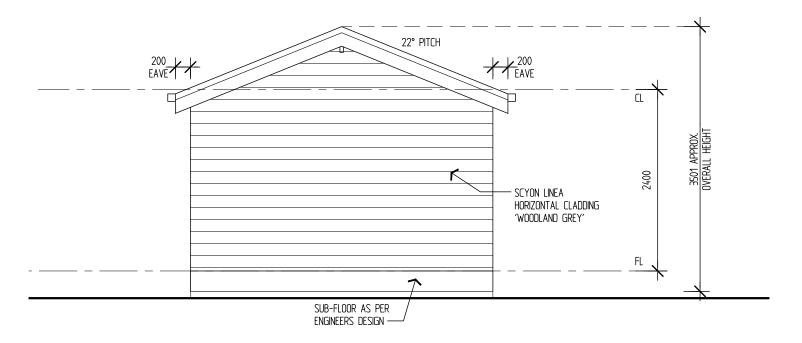

ELEVATION C

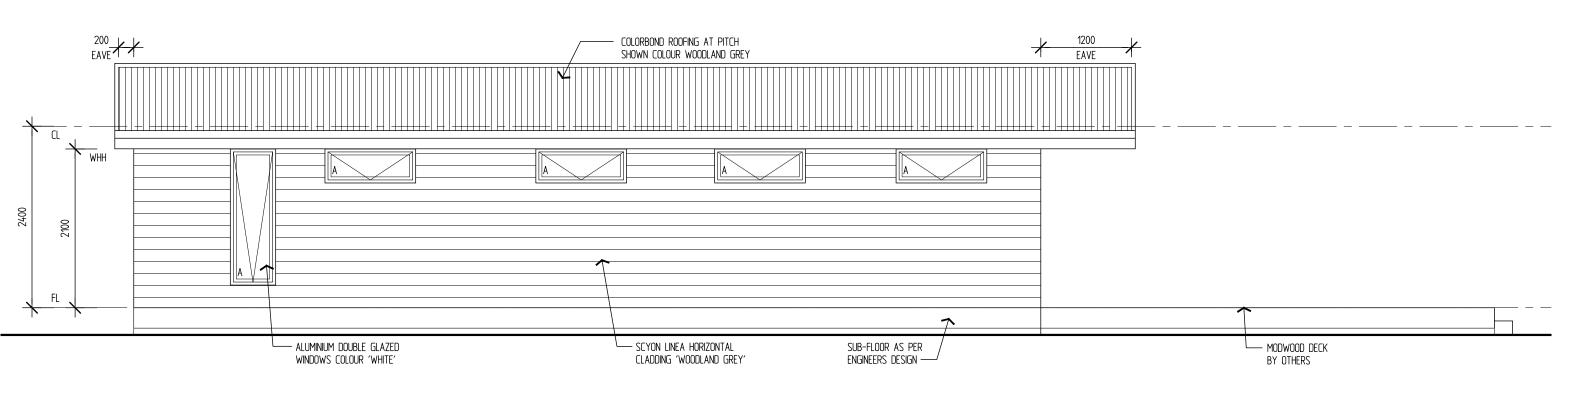

ELEVATION D


DO NOT SCALE OFF DRAWINGS. ALL DIMENSIONS TO BE CHECKED PRIOR TO COMMENCEMENT OF WORKS.

Proposed: Transportable Studio

344 Castlereagh Hwy, Spring Flat NSW

Client : Alina & Mick


Soul Space Studios For :-

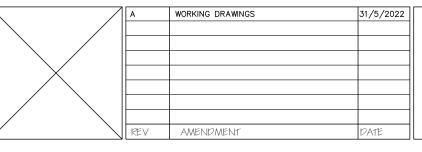




Avallon Building	Design Methers where	111 5ca
PO Box 170 Trafalgar Vic. 3824 Mob. 0419 598 662 E. design@avallon.com.au	© COPYRIGHT '2020' This document or any document forming port of this document remains the property of Availon Building Design & Drafting and may not be retained, copied or latered in whole or in port, or used without the written permission.	Dra Issi

mber	Working Drawings Elevations	:-
	Scale 1:50	Date 31/5/22
ming ne & d, t, or	Drawn MG	Job No. 1
	Issue A	Sheet 4 of 6

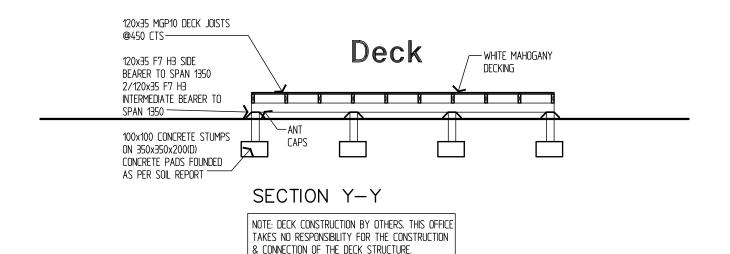

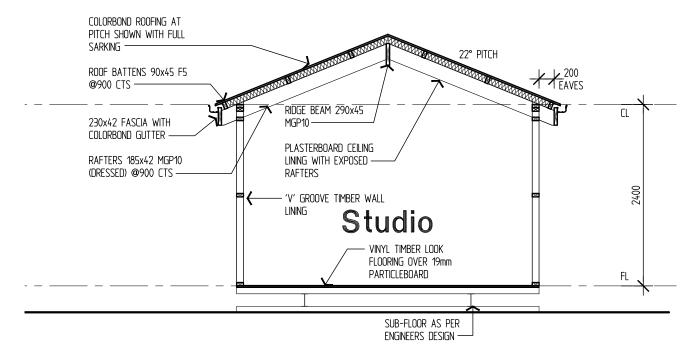

SECTION X-X

STUD SCHEDULE

MEMBER	SIZE	GRADE	CTS	SPAN
STUDS	90x45	F5	350	1200
NOGGINGS	70x35	F5	1200	
L/BEAR. TOP PLATE	2/90x45	F5		
TOP & BOTTOM PLATE	90x45	F5		
JAMB STUD	2/90x35	F5		1250
JAMB STUD	2/90x45	F5		2500
LINTEL	120x35	MGP10		1250
LINTEL	190x45	MGP10		2500

SOIL CLASSIFICATION CLASS: '?' REFER TO SOIL REPORT BY: ??

DATED: ??

REPORT NO: ??

NOTE:

- PROVIDE TERMITE TREATMENT TO A.S. 3660.1
- These drawings to be read in conjunction with ENGINEERS SPECIFICATIONS. ENGINEERS DETAILS AND SIZES TO TAKE PRECEDENCE.

ENERGY RATING REQUIREMENTS


- R6.0 INSULATION TO CEILING
- R2.7 INSULATION TO EXTERNAL WALLS
- R2.7 INSULATION TO BATH INTERNAL WALLS
- R2.0 INSULATION TO UNDER FLOOR
- ALUMINIUM AWNING DOUBLE GLAZED WINDOWS: U-VALUE 4.5, SHGC VALUE 0.5 OR BETTER
- ALUMINIUM FIXED DOUBLE GLAZED WINDOWS: U-VALUE 4.5, SHGC VALUE 0.61 OR BETTER
- ALUMINIUM DOUBLE GLAZED STACKER DOOR: U-VALUE 4.5, SHGC VALUE 0.5 OR BETTER

Proposed: Transportable Studio

344 Castlereagh Hwy, Spring Flat NSW

Client: Alina & Mick

Soul Space Studios For :-

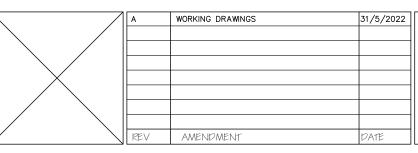



PO Box 170 Trafalgar Vic. 3824 Mob. 0419 598 662 E. design@avallon.com.au

47 1	ielgn Mers timber	111 50
1		

Deelgn Metters natur	1111.5	Working Drawings Section	:-	
	Scale	1:50	Date	31/5/22
OPYRIGHT '2020' ment or any document forming this document remains the of Availon Building Design &	Drawn	MG	Job No.	1
g and may not be retained, altered in whole or in part, or thout the written permission.	Issue	A	Sheet	5 of 6

DO NOT SCALE OFF DRAWINGS. ALL DIMENSIONS TO BE CHECKED PRIOR TO COMMENCEMENT OF WORKS.

ELECTRICAL LEGEND


- DOUBLE POWER POINT
- DOUBLE WEATHERPROOF POWER POINT
- © CEILING MOUNTED SPOTLIGHT
- \longrightarrow Wall mounted light
- SMOKE DETECTOR
- XL TASTIC HEAT/FAN/LIGHT
- SELF-SEALING CEILING EXHAUST FAN
- EXTERNAL SPOT LIGHT
- ₩ TV POINT
- PHONE POINT
- CEILING FAN WITH LIGHT
- SUB-BOARD FUSE BOX

- NOTES: LOCATIONS OF ALL ELECTRICAL AND SERVICE POINTS ARE APPROXIMATE ONLY AND SUBJECT TO POSITIONS OF STRUCTURAL MEMBERS.
- PROVIDE SMOKE DETECTORS WHERE INDICATED IN ACCORDANCE WITH A.S. 3786-1993 AND B.C.A.

WATTAGE ALLOWANCE:

Max. total wattage residence: 5 W/m sqr Residence floor area: 48m sqr Total allowable wattage: 240 W Total No. of lights: MAX. WATTAGÉ PER LIGHT: 16 W

NOTE: PERIMETER LIGHTING MUST BE EITHER CONTROLLED BY A DAYLIGHT SENSOR, OR HAVE AN AVERAGE LIGHT SOURCE EFFICACY OF NOT LESS THAN 40 LUMENS/W, AS PER

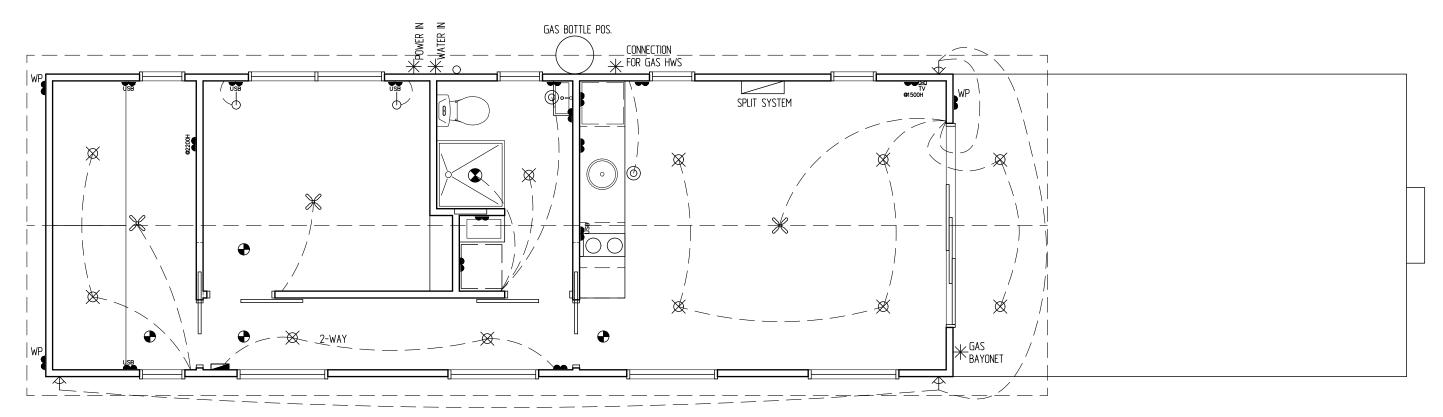

ELECTRICAL PLAN


DO NOT SCALE OFF DRAWINGS. ALL DIMENSIONS TO BE CHECKED PRIOR TO COMMENCEMENT OF WORKS.

Proposed: Transportable Studio

344 Castlereagh Hwy, Spring Flat NSW

Client : Alina & Mick

Soul Space Studios For :-

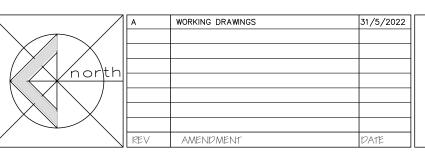



PO Box 170 Trafalgar Vic. 3824 Mob. 0419 598 662 E. design@avallon.com.au

4 Deelgn 95 Methers number	TITLE	Working Electri
	Scale	1:50
© COPYRIGHT '2020' This document or any document forming part of this document remains the property of Availan Buildina Desian &	Drawn	MG

	Working Drawings :— Electrical Plan		
^{5cale} 1:50	Date 31/5/22		
Drawn MG	Job No. 1		
Issue A	Sheet 6 of 6		